
## QUALITY ASSURANCE STATEMENT

A Quality Control and Assurance review has been performed on this document in accordance with the Timmons Group Quality Plan. The undersigned states that this document has been checked and reviewed in a manner commensurate with the level of detail for the type of submittal indicated below.


Project Manager

DEV/TEM/

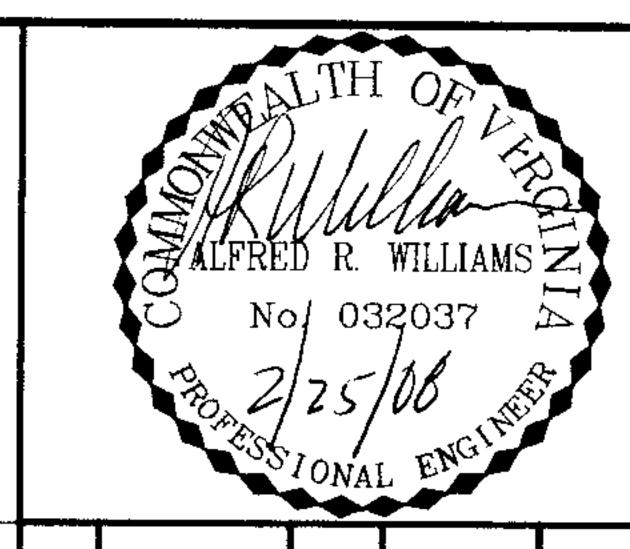

NORTH ELEMENTARY SCHOOL PUMPING STATION & FORCE MAIN

PRINCE GEORGE COUNTY, VIRGINIA

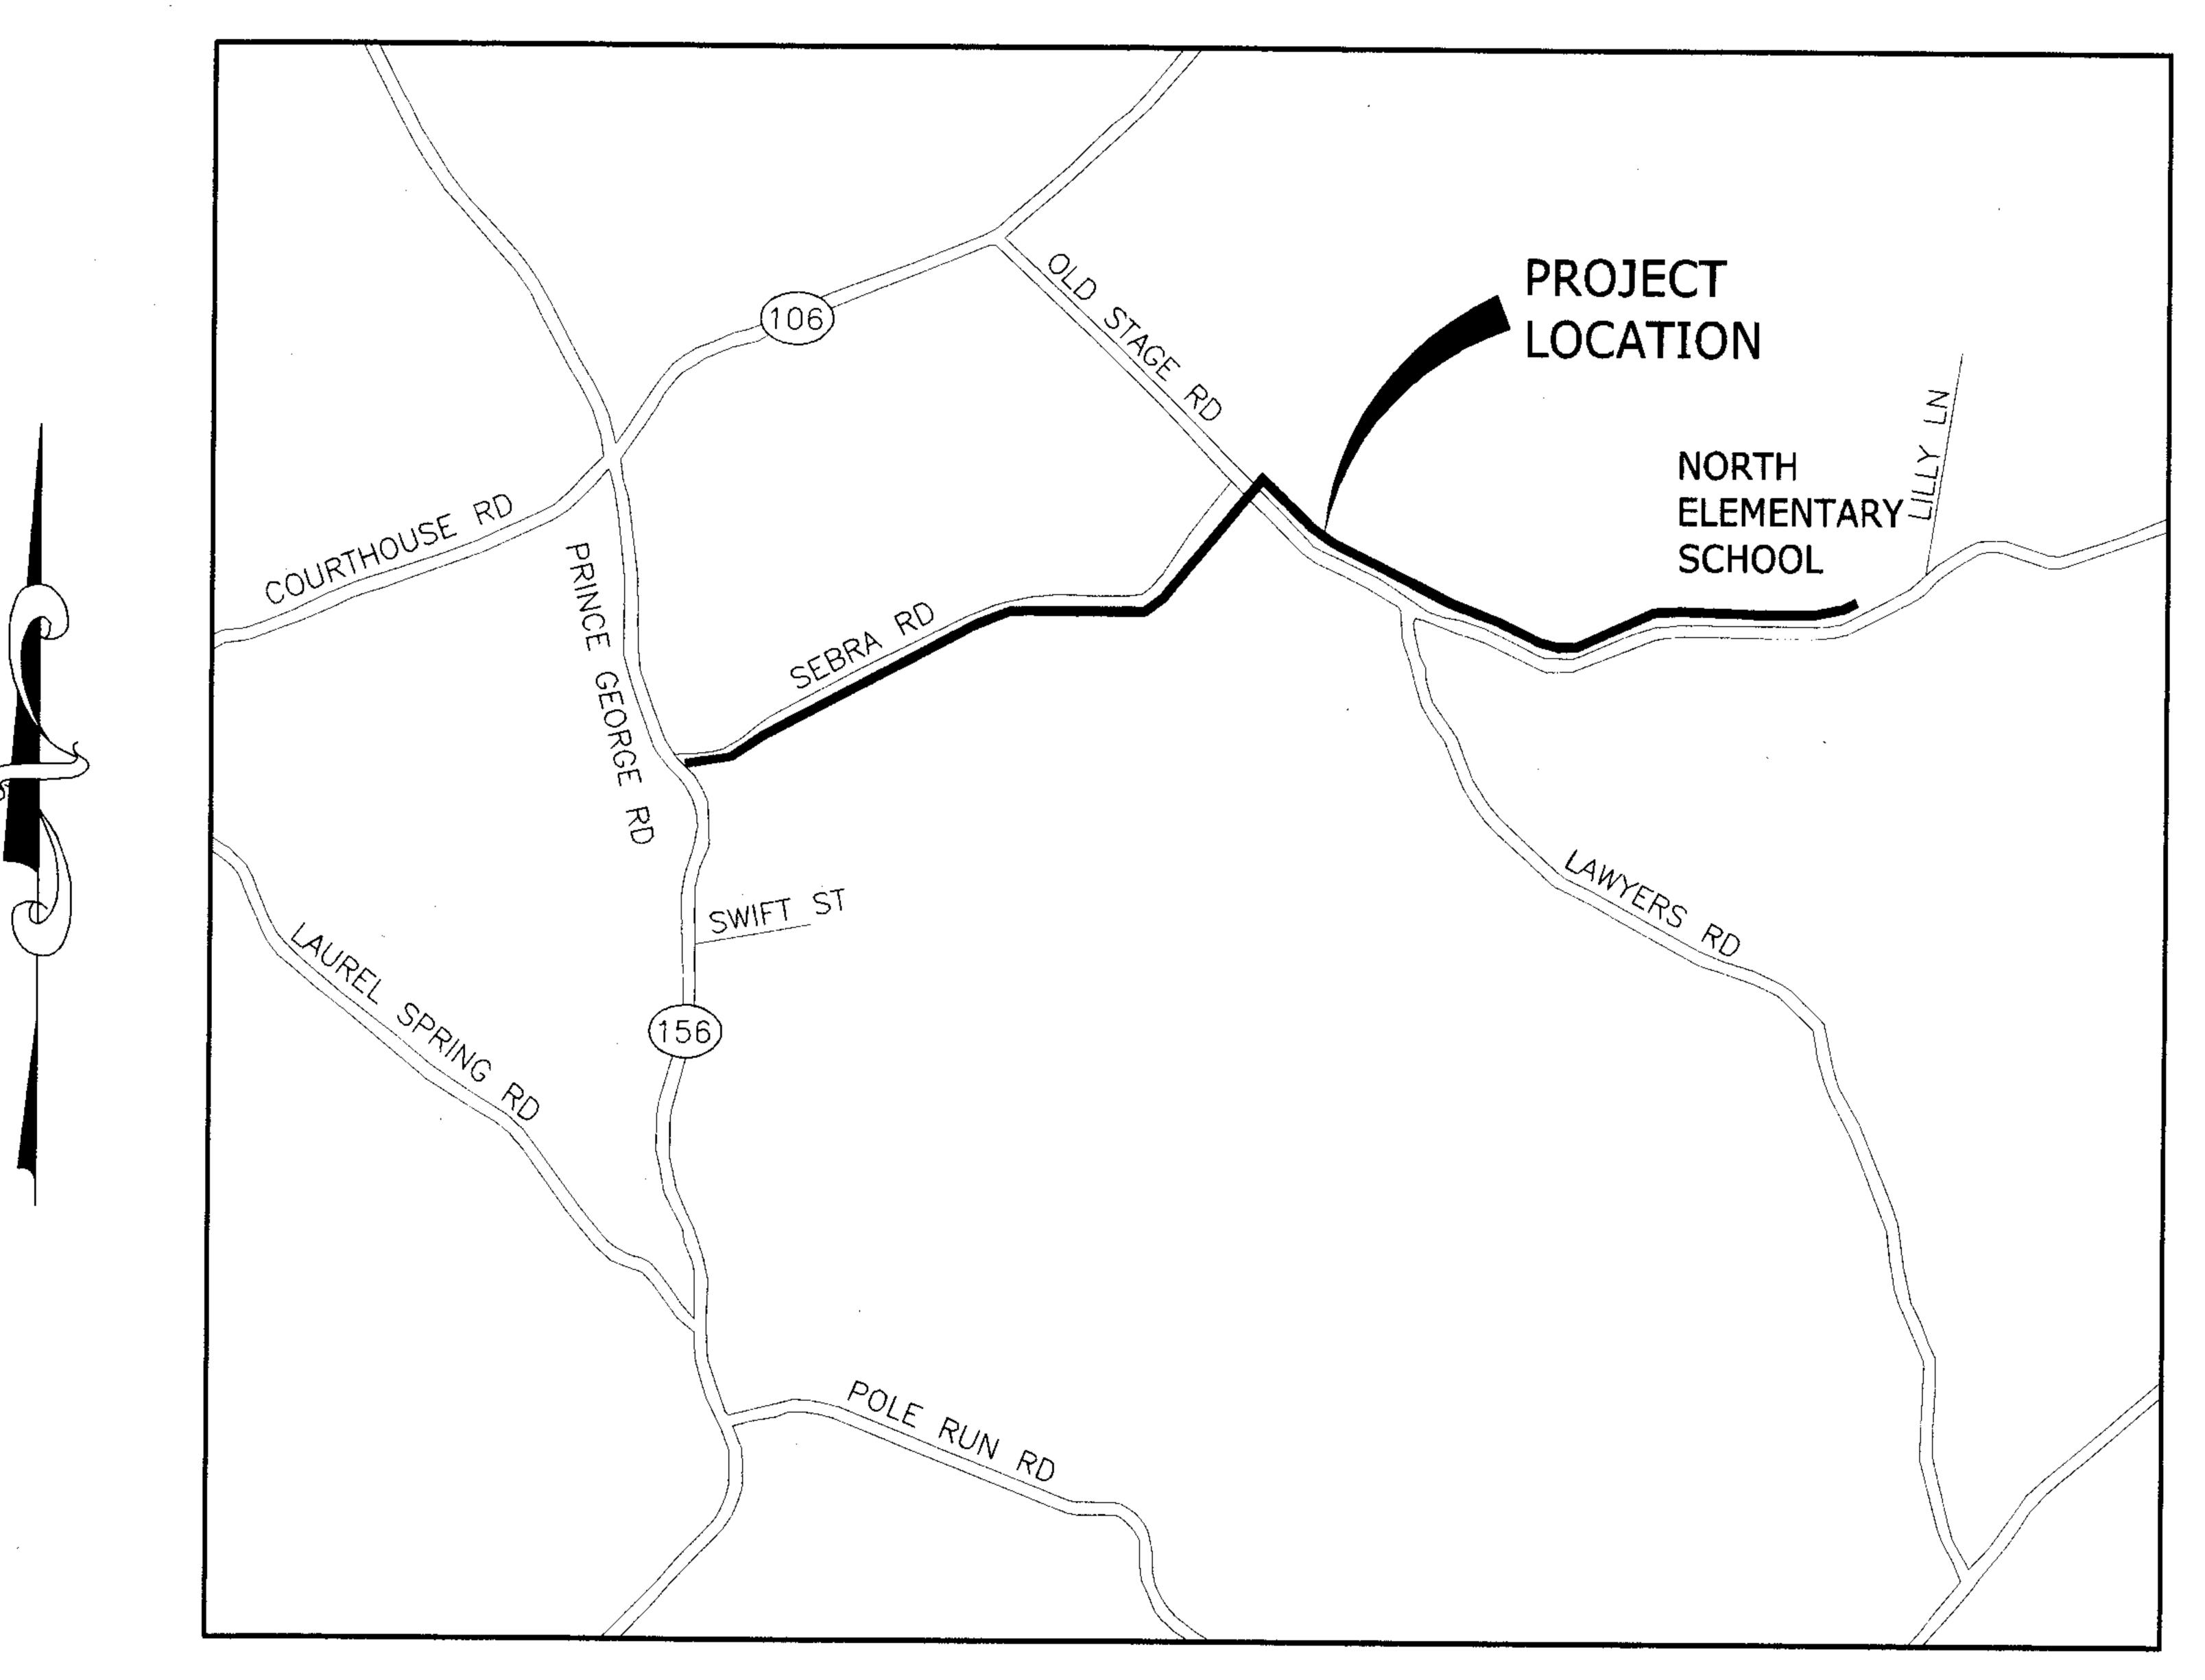

VICINITY MAP SCALE: 1" = 2,000'

PRINCE GEORGE COUNTY SCHOOL BOARD

FEBRUARY 25, 2008

## REVISIONS

T" *				
DATE	SHEET NUMBERS	DATE	SHEET NUMBERS	
		<del></del>		
			<u> </u>	
<u> </u>				
		·		

POPITI LIAMINEEK

RELEASED FOR CONSTRUCTION
4-22-08
4-22-08
LEM'Bride

## SHEET INDEX

•	
TITLE	SHEET
COVER	U1.0
INDEX SHEET	U1.1, U1.2
LEGEND & NOTES	U1.3
VDOT NOTES & TYPICAL DETAILS	U1.4
TYPICAL DETAILS	U1.5
E & S NOTES & DETAILS	U1.6
E & S SEEDING NOTES	U1.7
TRAFFIC CONTROL NOTES & DETAILS	U1.8
PLAN & PROFILE	U2.1-U2.1
PUMP STATION SITE PLAN, DETAILS AND PROFILE	U3.1
PUMP STATION DETAILS	U3.2
LAGOON CLOSURE PLAN	U4.1

THROUGH OURS.

THIS DRAWING PREPARED AT THE CORPORATE OFFICE

1001 Boulders Parkway, Suite 300 | Richmond TEL 804.200.6500 FAX 804.560.1016 www.ti

AIN Site Develop

GROODUP...

JOB NO.

24326

SHEET NO.