





## PUMP STATION SITE PLAN

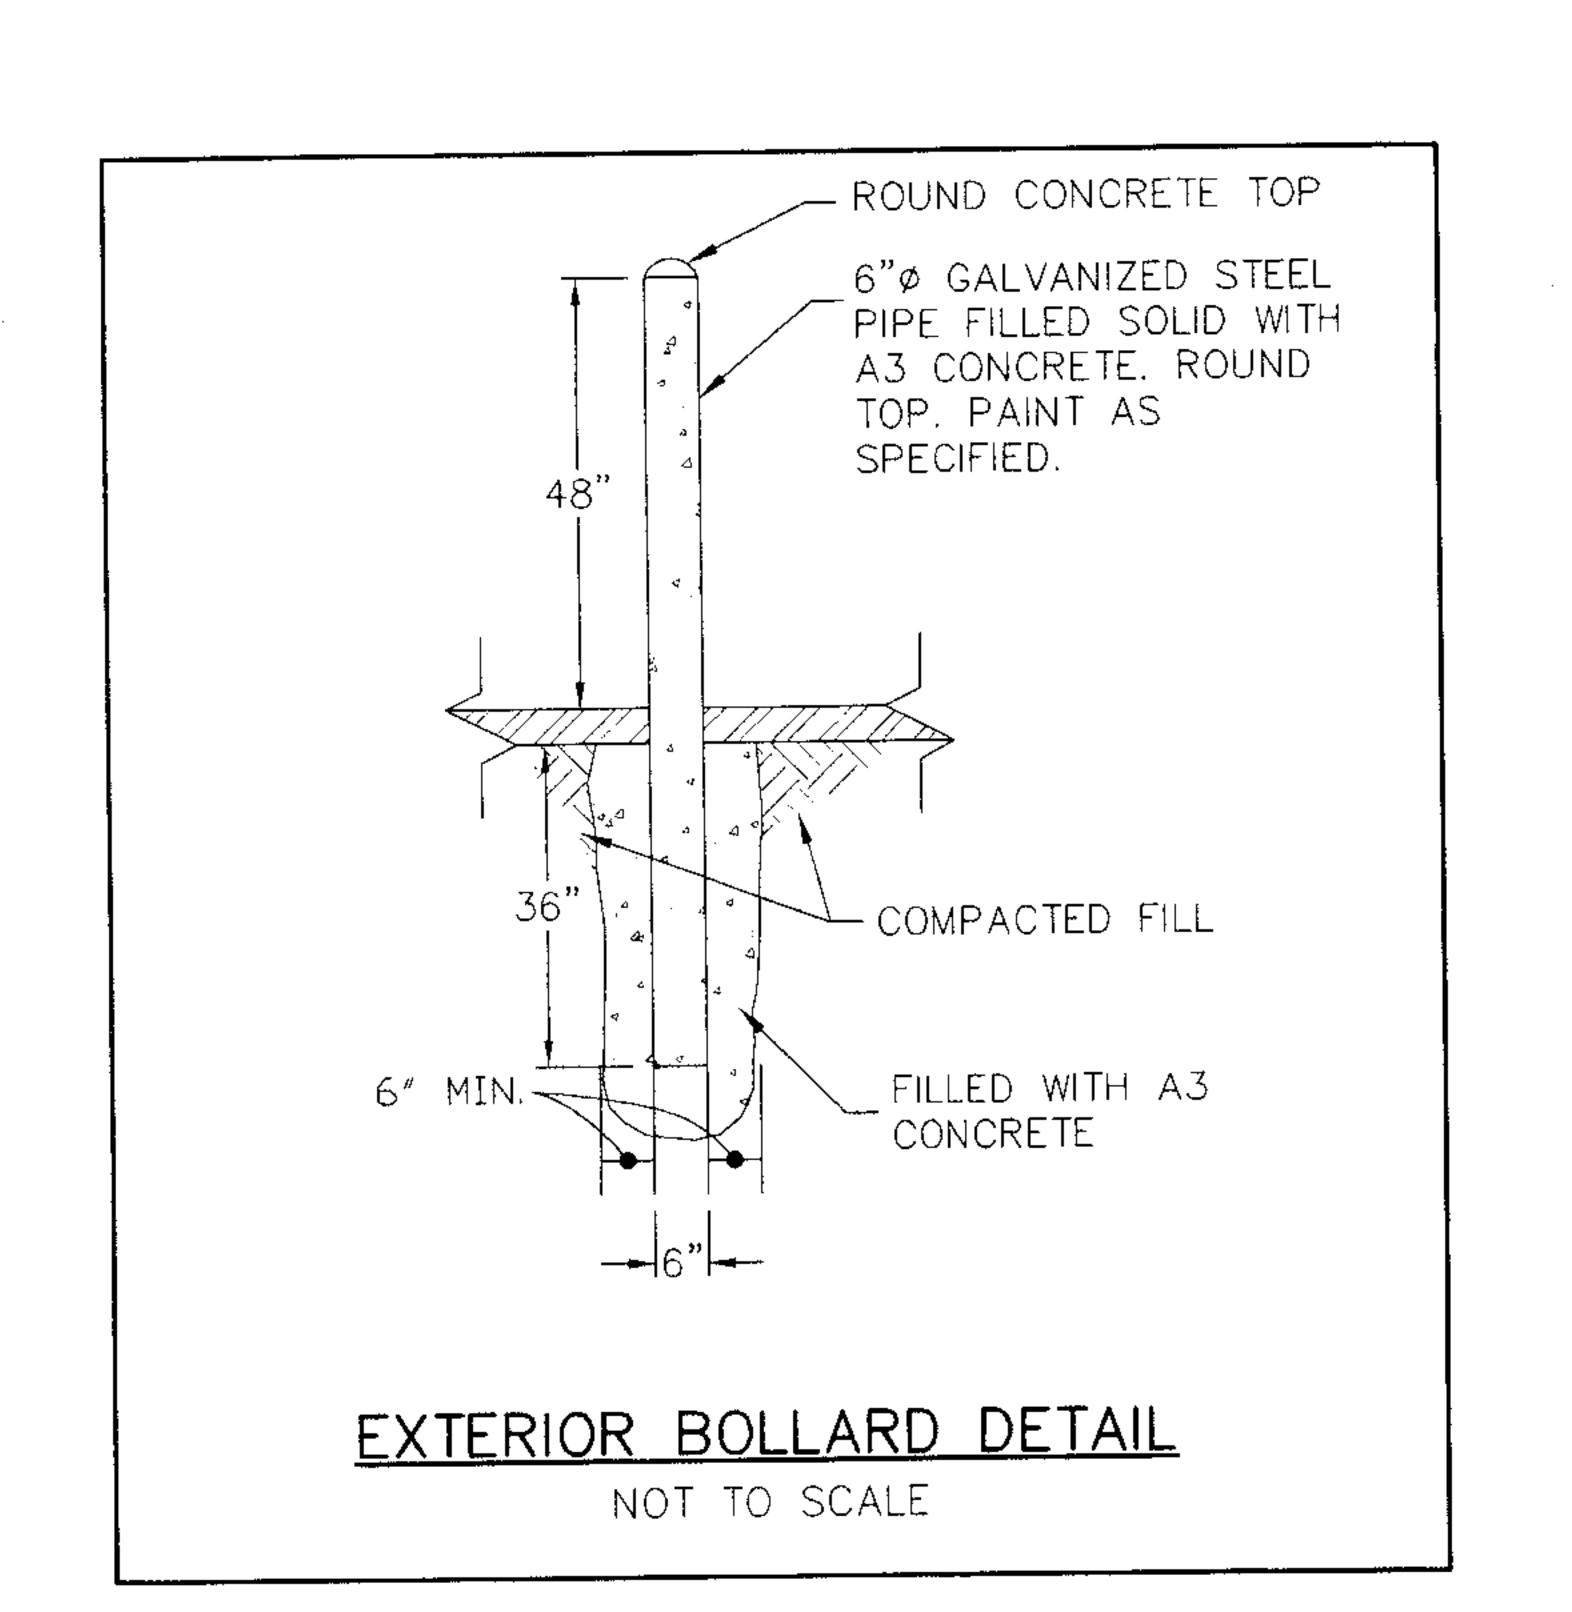

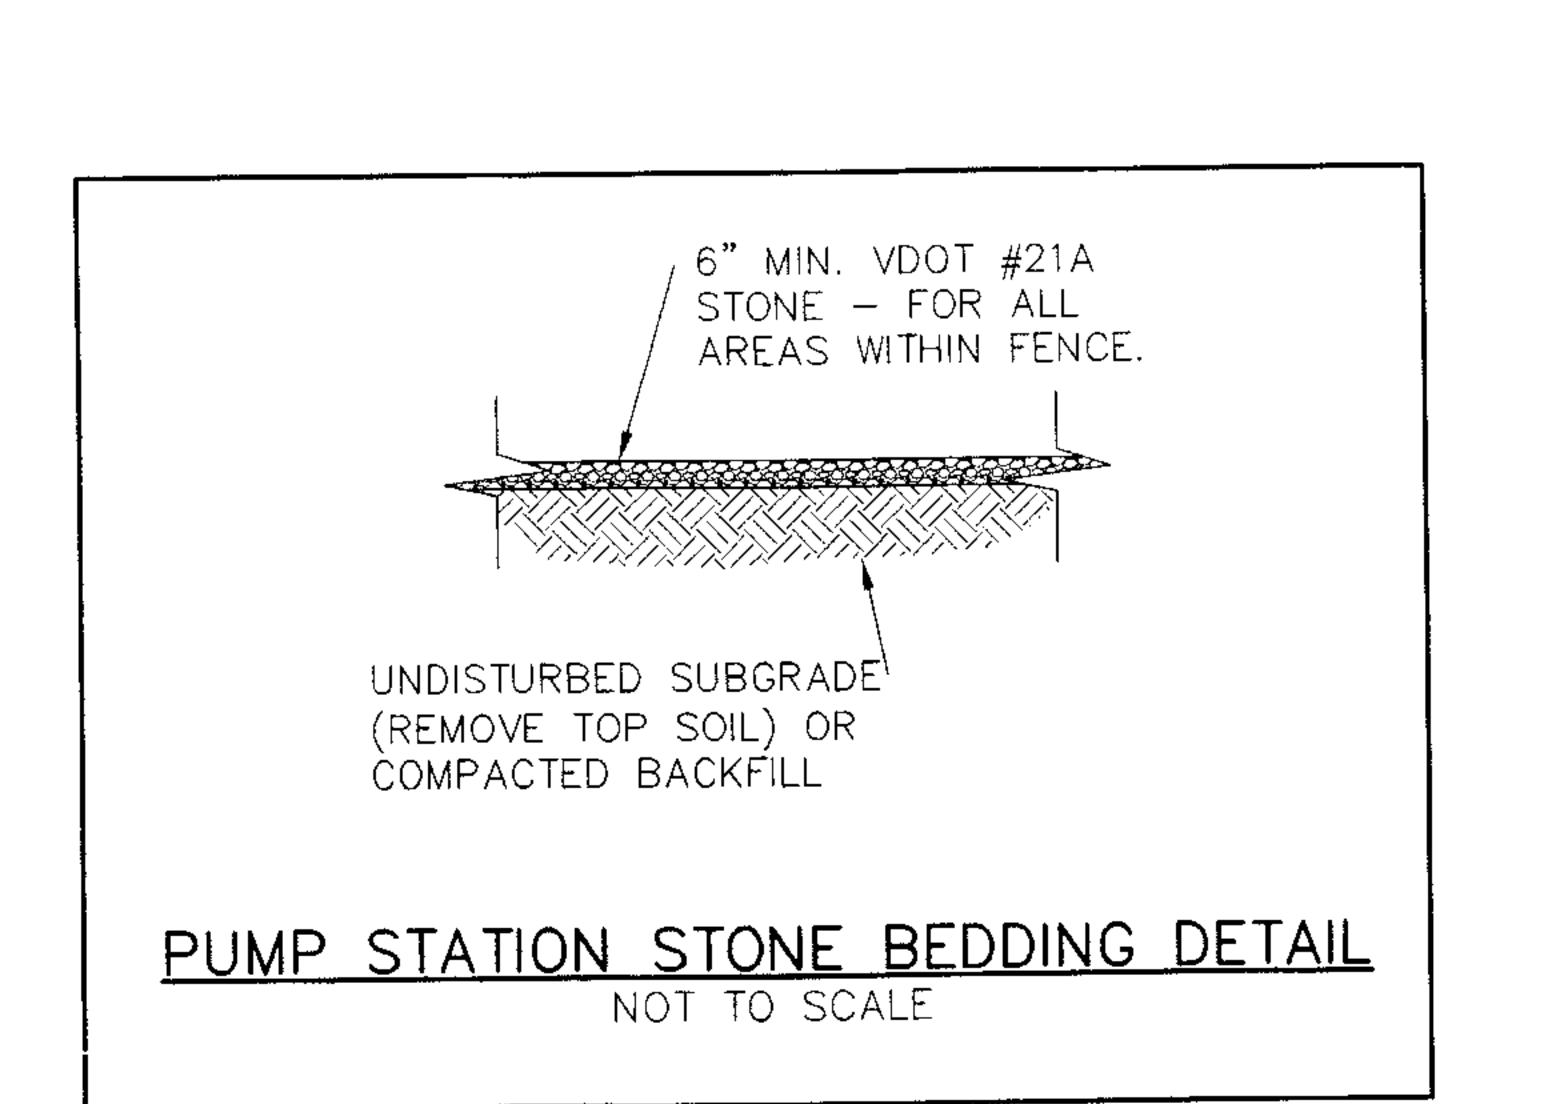

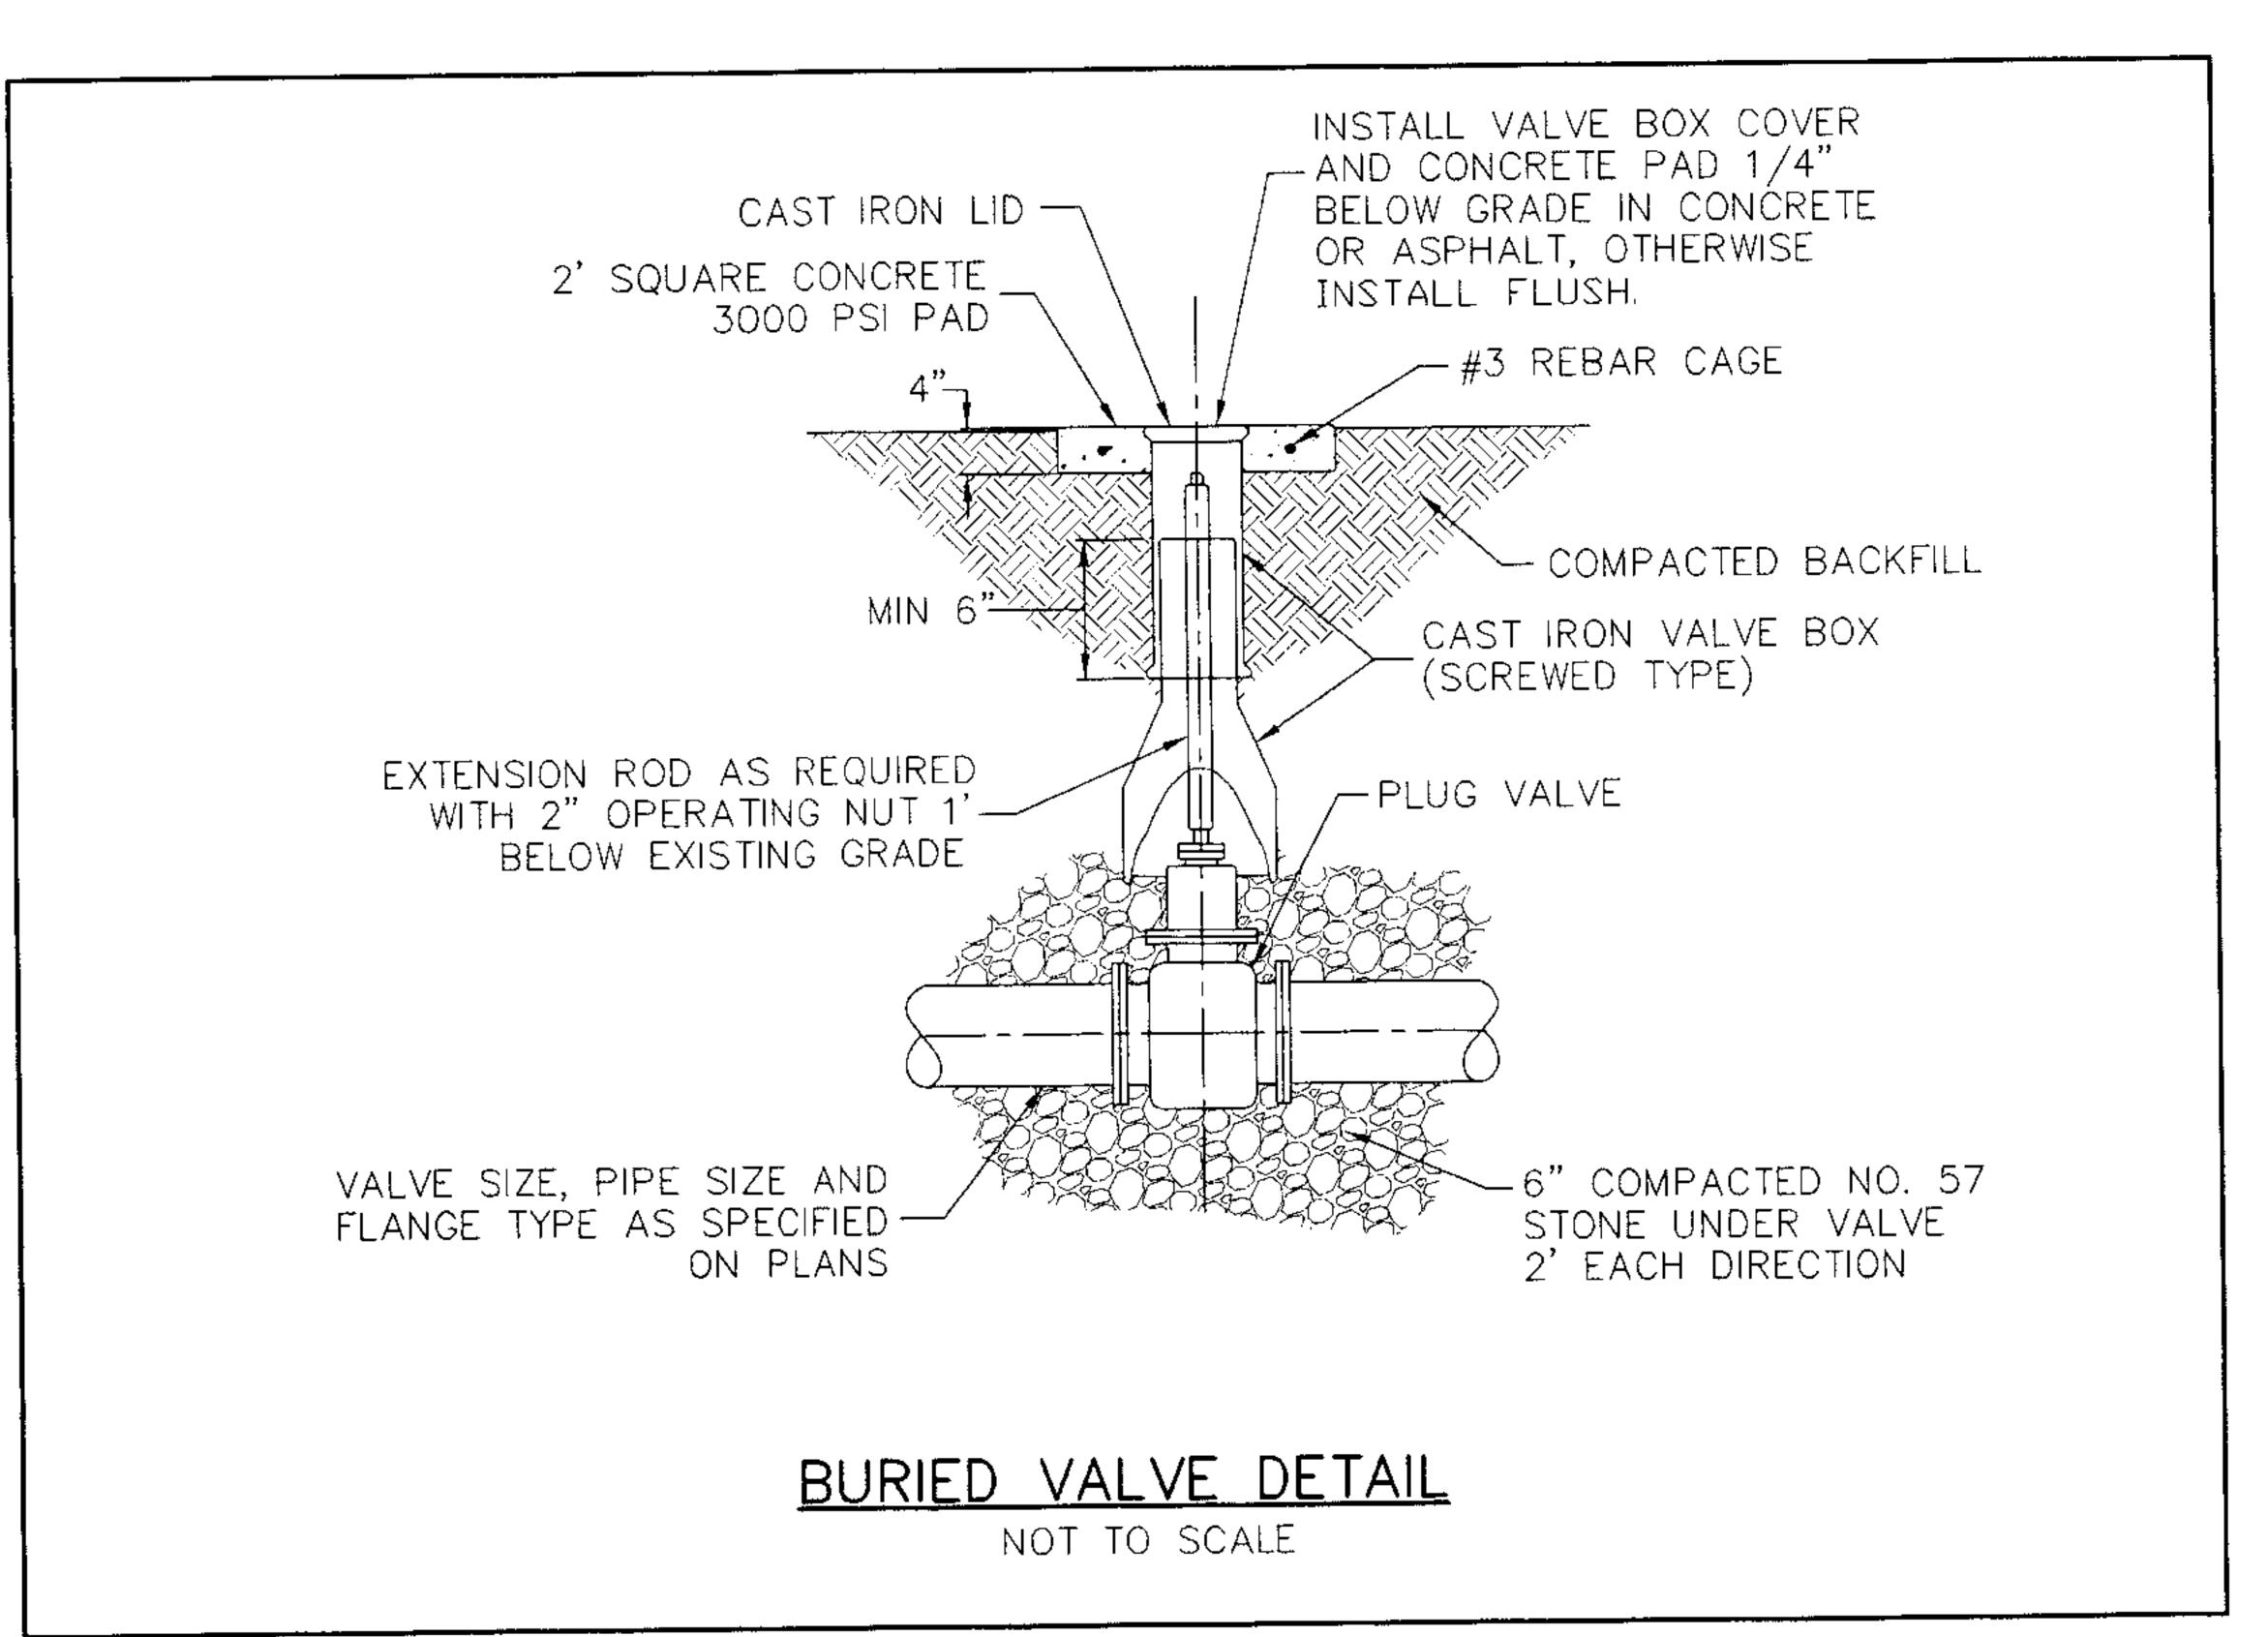

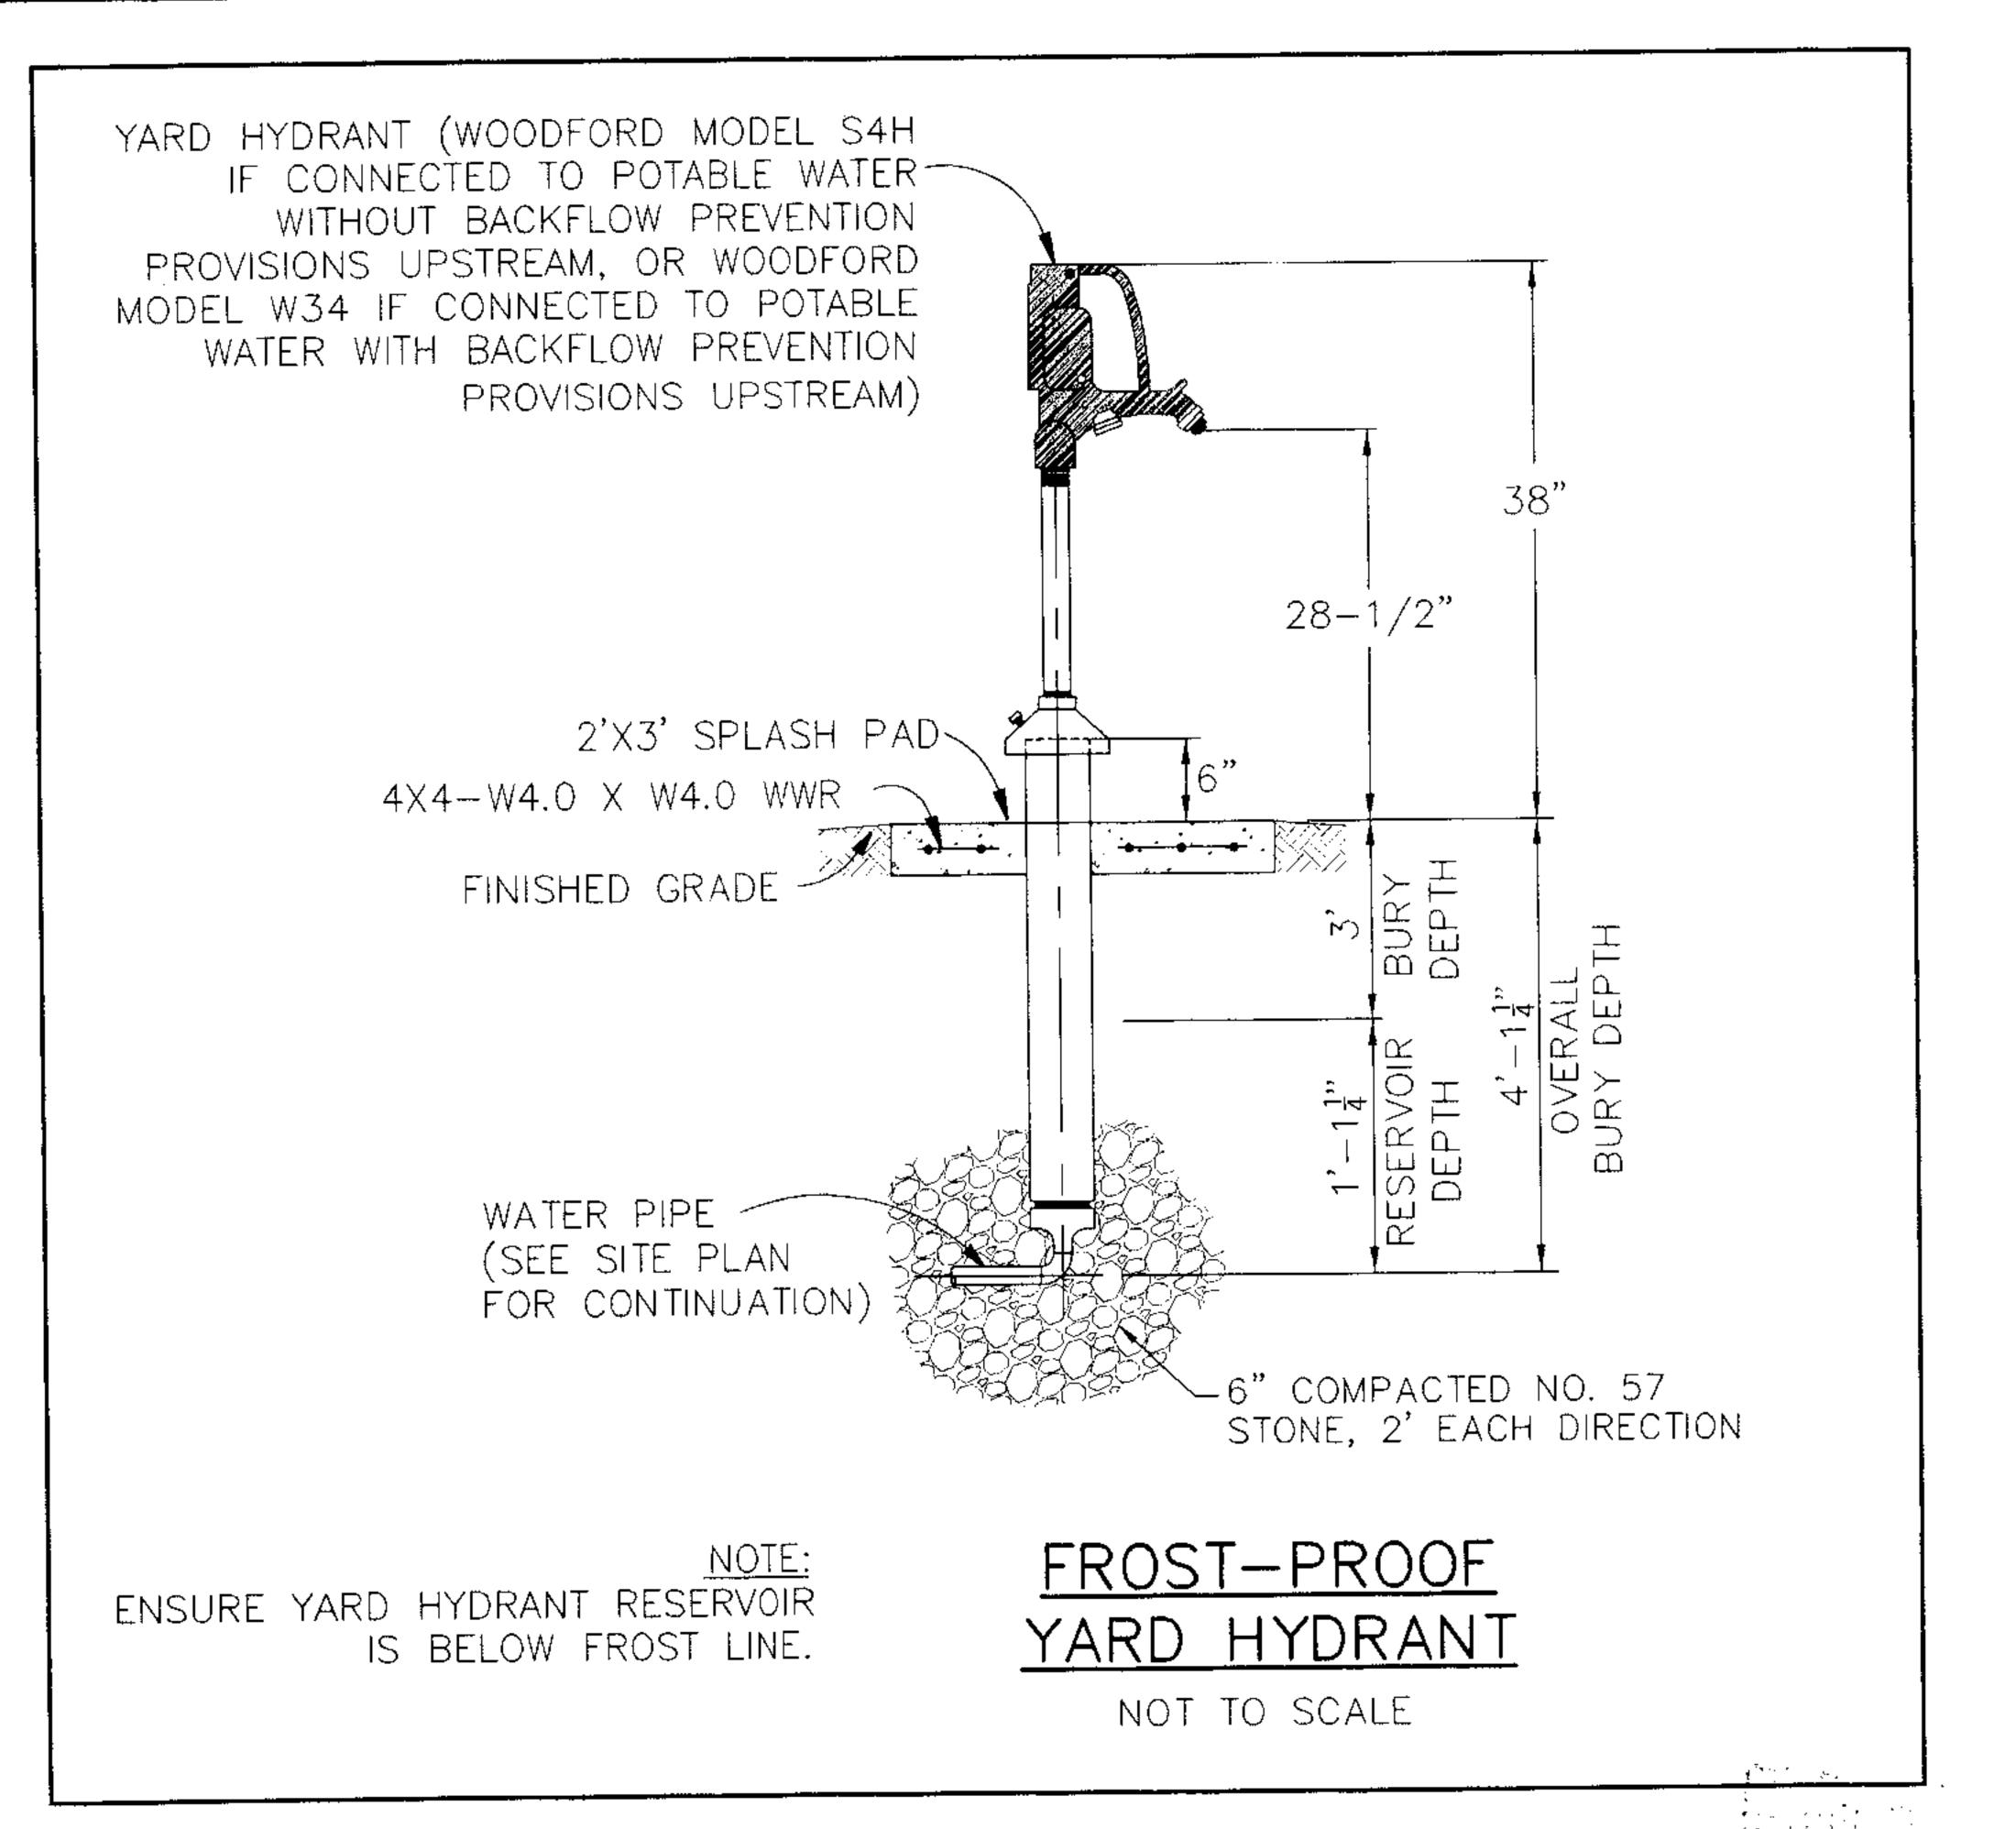

В.К.Ј. DESIGNED BY

CHECKED BY SCALE AS SHOWN